

MECHANICAL ABBREVIATIONS

AF	ABOVE FINISH FLOOR	HWP	HEATING WATER PUMP
AC	AIR COMPRESSOR	HX	HEAT EXCHANGER
AHU	AIR HANDLING UNIT	ID	INSIDE DIAMETER
AS	AIR SEPARATOR	I.E.	INVERT ELEVATION
A.T.C.	ARCHITECTURAL TRADES CONTRACTOR	IAH	INTAKE HOOD
B	BOILER	LAT	LEAVING AIR TEMPERATURE
B.A.S.	BUILDING AUTOMATION SYSTEM	LH	LATENT HEAT (MBH)
CAF	COMBUSTION AIR FAN	LWT	LEAVING WATER TEMPERATURE
CC	COOLING COIL	MAX	MAXIMUM
CFM	CUBIC FEET PER MINUTE	MBH	BTU PER HOUR (THOUSAND)
CHLR	CHILLER	MIN	MINIMUM
CHP	CONSOLE HEAT PUMP	M.T.C.	MECHANICAL TRADES CONTRACTOR
CONV	CONVECTOR	N.C.	NOISE CRITERIA
CT	COOLING TOWER	NFPA	NATIONAL FIRE PROTECTION ASSOCIATION
CU	CONDENSING UNIT	NTS	NOT TO SCALE
CUH	CABINET UNIT HEATER	P	PUMP
CV	CONTROL VALVE	PCR	PUMPED CONDENSATE RETURN
QWP	CHILLED WATER PUMP	PD	PRESSURE DROP
DB	DRY BULB	RCP	RADIANT CEILING PANEL
DFU	DUCT FURNACE	REQ'D	REQUIRED
DIA	DIAMETER	RG	RETURN GRILLE
DN	DOWN	RH	RELATIVE HUMIDITY
DFR	DAMPER	RLH	RELIEF HOOD
DS	DUCT SILENCER	RTU	ROOF TOP UNIT
EAT	ENTERING AIR TEMPERATURE	SD	SUPPLY DIFFUSER
EF	EXHAUST FAN	SF	SUPPLY FAN
EG	EXHAUST GRILLE	SG	SUPPLY GRILLE
E.T.C.	ELECTRICAL TRADES CONTRACTOR	SH	SENSIBLE HEAT (MBH)
EVR	EVAPORATOR	SM	SHEET METAL
EWT	ENTERING WATER TEMPERATURE	SQ. FT.	SQUARE FEET
EXH	EXHAUST	SST	SATURATED SUCTION TEMPERATURE
EXIST	EXISTING	STR	STRAINER
FF	FINISH FLOOR	TC	TOTAL COOLING (MBH)
FFM	FEET PER MINUTE	TCL	TEMPERATURE CONTROL
FT	FEET	T4P	TEMPERATURE & FRESSURE RELIEF VALVE
FTR	FINNED TUBE RADIATION	TYP	TYPICAL
FU	FURNACE	UH	UNIT HEATER
GAL	GALLON	VAV	VARIABLE AIR VOLUME BOX
GFRH	GAS FIRED RADIANT HEATER	VRH	VARIABLE AIR VOLUME REHEAT BOX
GR	GRILLE	FFVAV	FAN POWERED VARIABLE AIR VOLUME BOX
H	HUMIDIFIER	V.F.D.	VARIABLE FREQUENCY DRIVE
HC	HEATING COIL	ZD	ZONE DAMPER
HD	HEAD (FT)	X-SA	EXISTING ITEM (EXISTING SUPPLY AIR DUCT)
HP	HORSE POWER		
HHP	HORIZONTAL HEAT PUMP		
HTG	HEATING		
HVAC	HEATING, VENTILATION, & AIR CONDITIONING		

HVAC DUCTWORK SYMBOLS

	SUPPLY AIR DUCT RISER
	RETURN AIR DUCT RISER
	OUTSIDE AIR DUCT RISER (AS NOTED)
	EXHAUST AIR DUCT
	INSULATED DUCTWORK (AS NOTED)
	SUPPLY AIR DIFFUSER (SQUARE)
	SUPPLY AIR DIFFUSER (INLINE)
	SURFACE MTD. GRILLE
	SUPPLY AIR DIFFUSER (ROUND)
	CONICAL TAKE-OFF
	CONICAL TAKE-OFF W/ DAMPER
	BALANCE DAMPER
	RETURN AIR DUCT BOOT
	ECCENTRIC REDUCER
	CONCENTRIC REDUCER
	VERTICAL FIRE DAMPER
	HORIZONTAL FIRE DAMPER
	VERTICAL SMOKE DAMPER
	HORIZONTAL SMOKE DAMPER
	VERTICAL FIRE / SMOKE DAMPER
	HORIZONTAL FIRE / SMOKE DAMPER
	DUCT SMOKE DETECTOR, INSTALLED BY M.T.C. PROVIDED & WIRED BY E.T.C.
	UNIT HEATER
	CEILING EXHAUST FAN
	ROOF MOUNTED EXHAUST FAN
	DEMOLITION

HVAC DUCTWORK

—SA—	SUPPLY AIR DUCT
—X-SA—	EXIST SUPPLY AIR DUCT
—RA—	RETURN AIR DUCT
—X-RA—	EXIST RETURN AIR DUCT
—OA—	OUTSIDE AIR DUCT
—X-OA—	EXIST OUTSIDE AIR DUCT
—EA—	EXHAUST AIR DUCT
—X-EA—	EXIST EXHAUST AIR DUCT

HVAC DUCTWORK & DIFFUSER TAGS

SD-1	250	TAG	CFM
8"	TYP 4	NECK SIZE	REMARKS

MISCELLANEOUS NOTES

	POINT OF CONNECTION BETWEEN NEW AND EXISTING
	POINT OF EXISTING TO REMAIN AND EXISTING TO BE REMOVED.
	INDICATES PLAN NOTE
	INDICATES DEMOLITION NOTE
	DETAIL BUBBLE DETAIL NUMBER PAGE LOCATION
	INDICATES DIRECTION OF DETAIL SECTION

TEMPERATURE CONTROL SYMBOLS

	THERMOSTAT
	PROGRAMMABLE THERMOSTAT
	THERMOSTAT (W/ NIGHT SETBACK)
	ROOM SENSOR
	HUMIDISTAT
	PRESSURE GAUGE
	DAMPER (ELECTRIC OPERATION)
	DAMPER (PNEUMATIC OPERATION)
	DAMPER BLADES

HVAC PIPING

—CWS—	CHILLED WATER SUPPLY
—CWR—	CHILLED WATER RETURN
—CTS—	COOLING TOWER WATER SUPPLY
—CTR—	COOLING TOWER WATER RETURN
—HPS—	HEAT PUMP WATER SUPPLY
—HPR—	HEAT PUMP WATER RETURN
—HS—	HEATING WATER SUPPLY
—HR—	HEATING WATER RETURN
—DX—	DIRECT EXPANSION
—CD—	CONDENSATE DRAIN
—CS—	CONDENSER WATER SUPPLY
—CR—	CONDENSER WATER RETURN
—DWS—	SUCTION (DIRECT EXPANSION)
—DXL—	LIQUID (DIRECT EXPANSION)
—ST (0-20)—	LOW PRESSURE STEAM (0-20 LBS.)
—ST (21-15)—	MEDIUM PRESSURE STEAM (21-15 LBS.)
—ST (16+)—	HIGH PRESSURE STEAM (16 LBS. & ABV.)
—SC—	STEAM CONDENSATE (GRAVITY)
—SCP—	PUMPED STEAM CONDENSATE
—SC (BP)—	STEAM CONDENSATE BOILER FEED

HVAC PIPING SYMBOLS

	FLOW DIRECTION
	PIPING DROP
	PIPING RISE
	INLINE PIPING DROP
	INLINE PIPING RISE
	PIPING TEE
	PIPING ELBOW
	THERMOMETER
	PUMP
	UNION
	PIPE ANCHOR
	PIPE GUIDE
	BACK FLOW PREVENTER
	PIPE CAP
	PIPE BREAK
	THERMOMETER WELL
	EXPANSION LOOP
	EXPANSION COMPENSATOR
	FLOAT & THERMOSTATIC STEAM TRAP
	INVERTED BUCKET STEAM TRAP

HVAC PIPING VALVES

	GATE VALVE
	GAS COCK
	CHECK VALVE
	BALANCE COCK
	CIRCUIT SETTER
	TWO-WAY CONTROL VALVE
	THREE-WAY CONTROL VALVE
	GLOBE VALVE
	BALL VALVE
	SOLENOID VALVE
	EXPANSION VALVE WITH THERMOSTATIC BULB
	PLUG VALVE
	BUTTERFLY VALVE
	RELIEF VALVE
	HOSE & DRAIN END VALVE
	PRESSURE RELIEF VALVE
	PRESSURE REDUCING VALVE
	TRIPLE DUTY VALVE
	GAS PRESSURE REGULATOR
	STRAINER (BLOW-OFF)

GENERAL HVAC NOTES

- LOCATE EXHAUST OUTLETS OF VENTILATION SYSTEMS AND COMBUSTION EQUIPMENT STACKS AT LEAST 10 FEET FROM OUTDOOR AIR INTAKES.
- LOCATE OUTDOOR INTAKES AT LEAST 6 FEET ABOVE GROUND LEVEL OR 3 FEET ABOVE ROOF LEVEL UNLESS OTHERWISE INDICATED.
- NOTIFY OWNER OF ANY PIPING OR DUCTWORK DEMOLITION THAT MAY AFFECT NORMAL OPERATION OF OTHER AREAS.
- FIELD VERIFY LOCATIONS OF EXISTING PIPING THAT MAY CONFLICT WITH NEW CONSTRUCTION AND RELOCATE AS NEEDED.
- LOCATIONS OF THE THERMOSTATS TO BE VERIFIED IN FIELD.
- COORDINATE LOUVER SIZES WITH ARCHITECTURAL TRADES PRIOR TO CONSTRUCTION.
- CONTRACTOR SHALL COORDINATE ALL WORK WITH OTHER DISCIPLINES PRIOR TO CONSTRUCTION TO AVOID CONFLICTS.
- PROVIDE MANUAL AIR VENTS WITH ¾" HOSE CONNECTION AT ALL HIGH POINTS.
- THE CONTRACTOR SHALL FIELD VERIFY THE SIZES, LOCATION, ELEVATIONS, AND DETAILS OF ALL EXISTING CONDITIONS THAT MAY AFFECT THE WORK.
- THE CONTRACTOR SHALL BE RESPONSIBLE FOR MAINTAINING THE INTEGRITY OF ALL EQUIPMENT AND MATERIALS IN A "NEW" CONDITION DURING CONSTRUCTION.
- ALL WORK SHALL BE PERFORMED BY LICENSED CONTRACTORS AND SUBCONTRACTORS AS REQUIRED BY LAW.
- ALL WORK SHALL CONFORM TO MICHIGAN MECHANICAL CODE, LATEST APPLICABLE EDITION.
- ALL DUCT DIMENSIONS SHOWN ARE INSIDE CLEAR DIMENSION.
- IF THERE IS CONFLICTING INFORMATION IN THE PLANS OR SPECIFICATIONS THE MORE STRINGENT AND GREATER COST ITEM SHALL BE USED.
- DRAWINGS INDICATE REQUIRED SIZES AND POINTS OF TERMINATION OF PIPES AND DUCTS AND SUGGESTED ROUTES. IT IS NOT INTENTION OF DRAWINGS TO INDICATE ALL NECESSARY OFFSETS. INSTALL WORK IN MANNER TO CONFORM TO STRUCTURE, AVOID OBSTRUCTIONS, PRESERVE HEADROOM AND KEEP OPENINGS AND PASSAGEWAYS CLEAR. DO NOT SCALE FROM DRAWINGS.

REVISIONS			

DRAWN
NAS
APPROVED
CTH



MATRIX
CONSULTING ENGINEERS, INC.

1601 E. GRAND RIVER AVE.
LANSING, MI 48206
PHONE (313) 487-2511
FAX (313) 487-2544
administrators@matrixcei.com
Matrix Project No. 10136.00

OAKLAND UNIVERSITY PAVILION

HVAC MODIFICATIONS

SHEET DESCRIPTION	
MECHANICAL SYMBOLS, NOTES, AND ABBREVIATIONS	
DATE	6/16/11
PROJECT NUMBER	10136.01
SHEET NUMBER	M-100

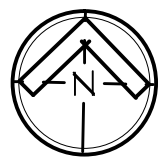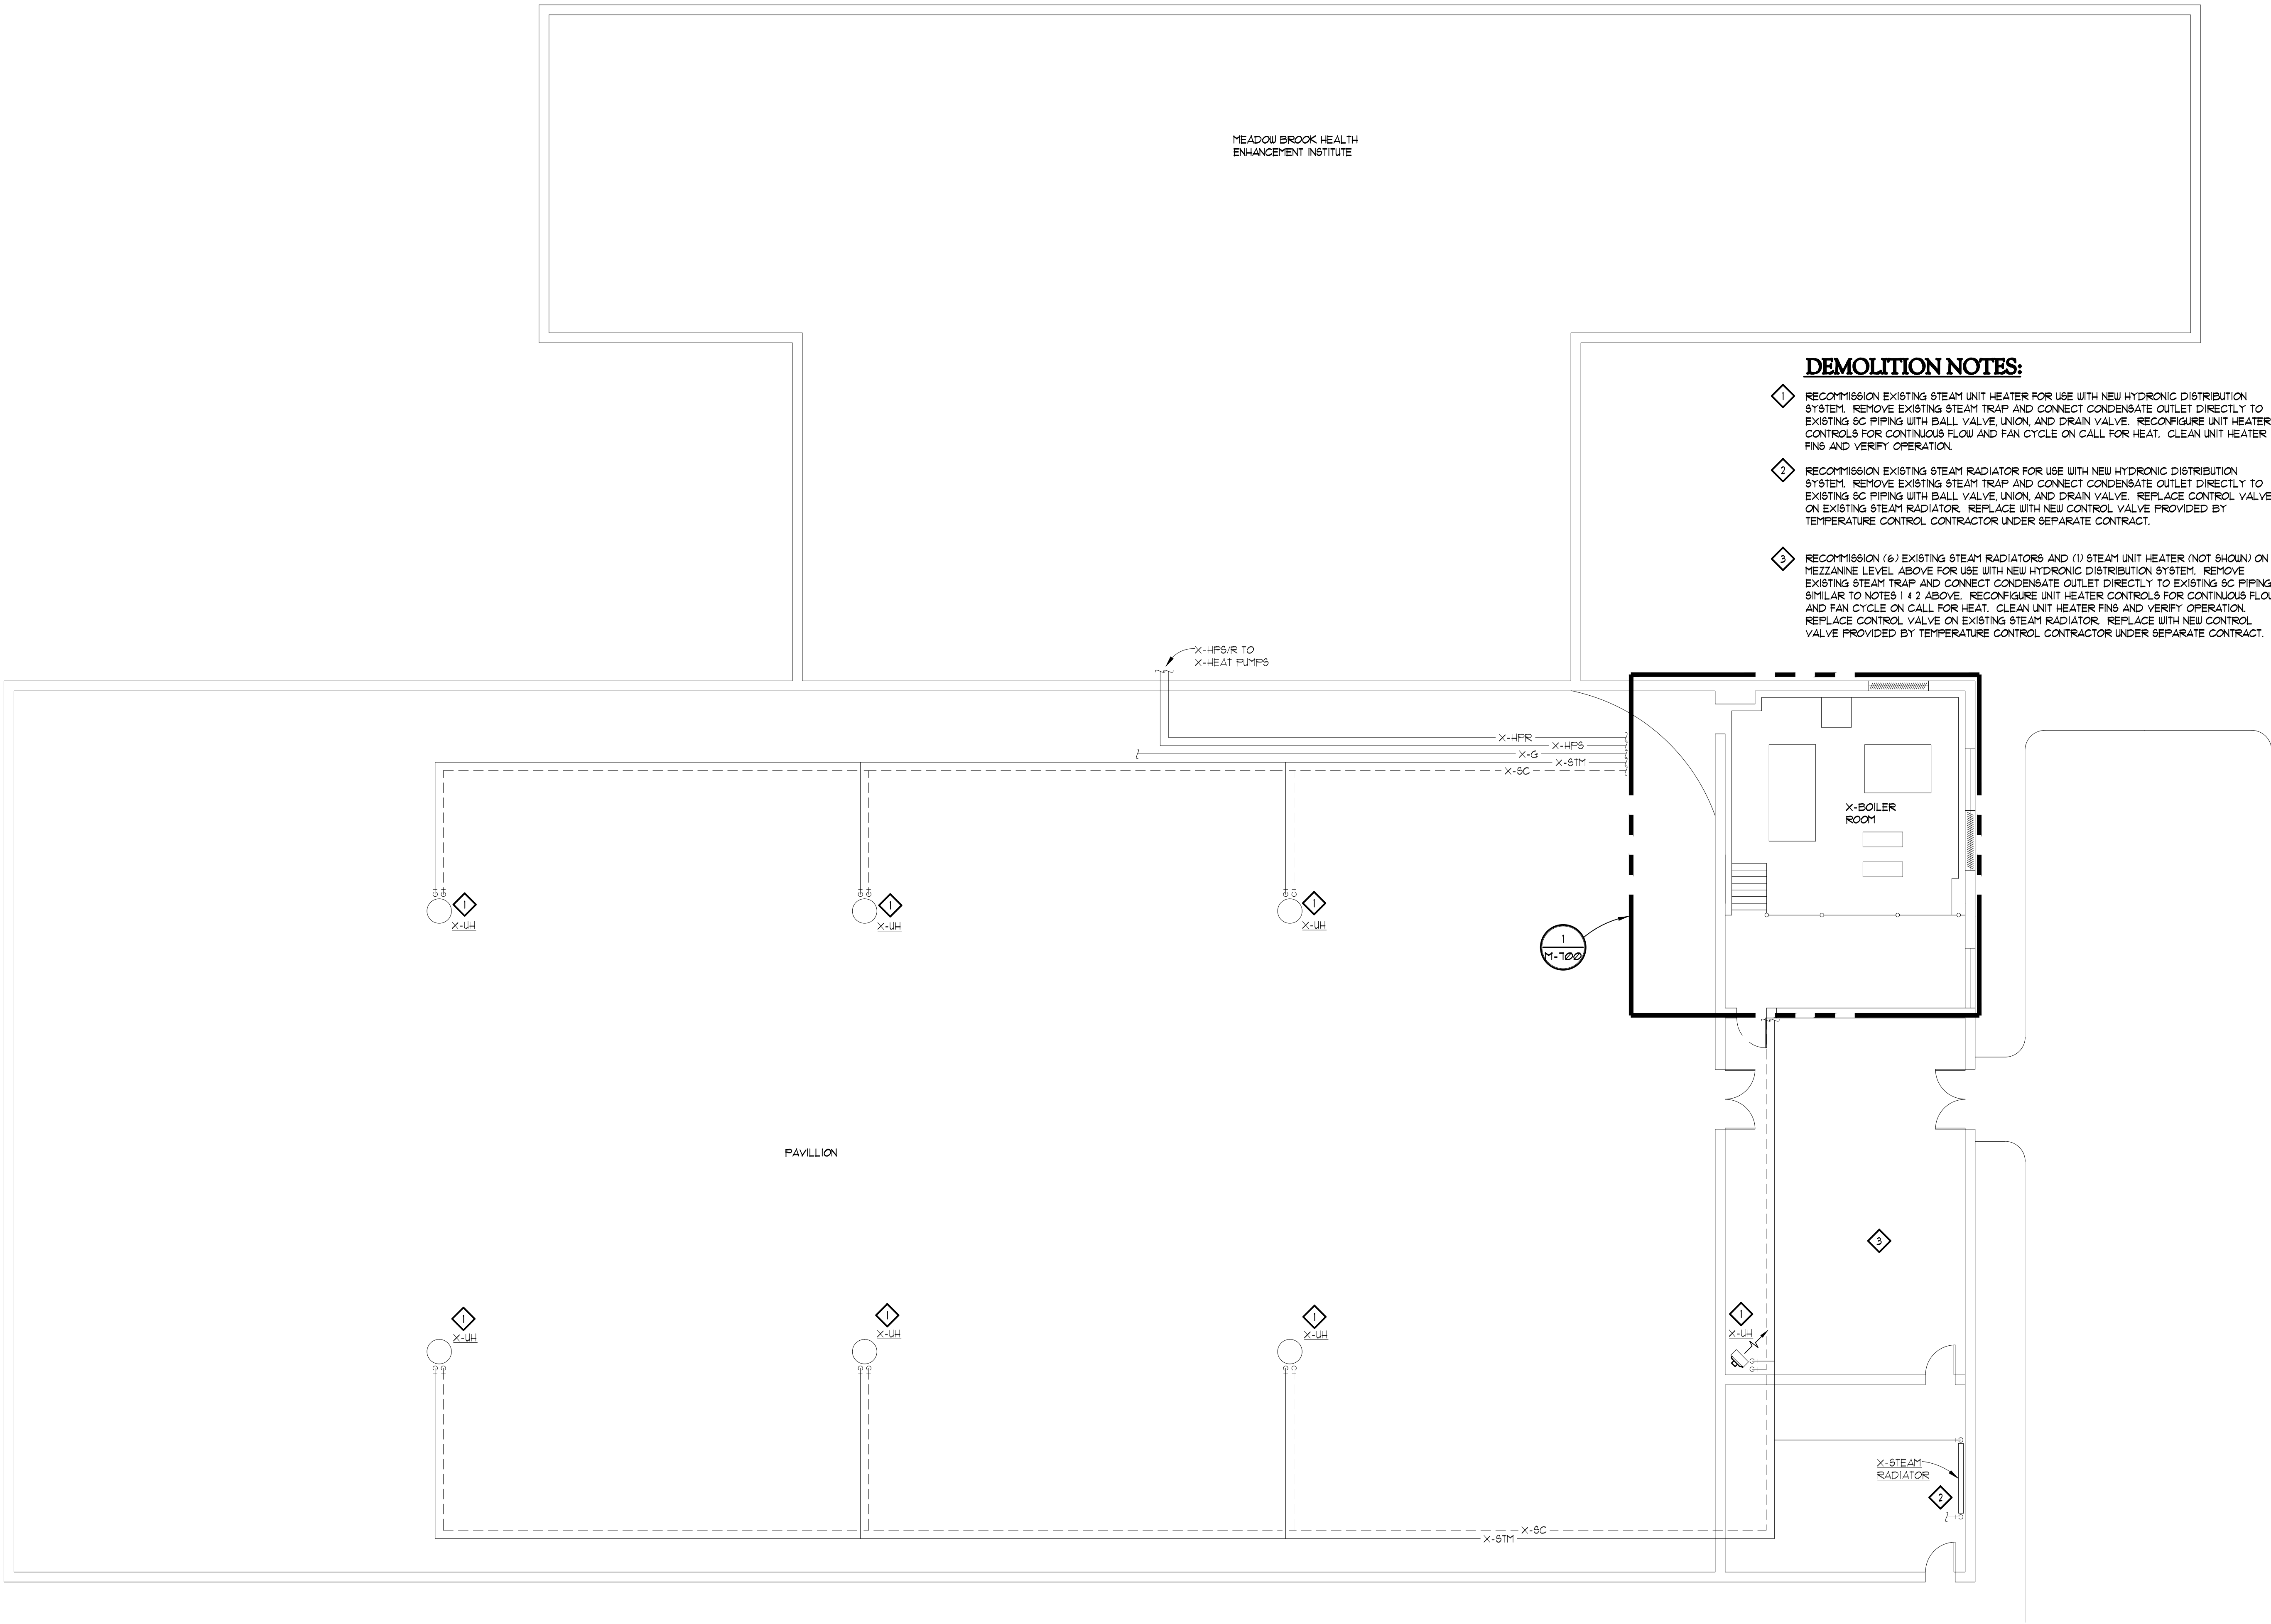

0 5 10 20
SCALE: 1/8" = 1'-0"

FLOOR PLAN HVAC - DEMOLITION

REVISIONS			

DRAWN
NAS

APPROVED
CTH

1601 E. GRAND RIVER AVE
LANSING, MI 48206
PHONE 617 487 2511
FAX 617 487 2244
admin@matrixeng.com
Matrix Project No. 10136.01

MATRIX
CONSULTING ENGINEERS, INC.

PROJECT

OAKLAND UNIVERSITY PAVILLION


HVAC MODIFICATIONS

SHEET DESCRIPTION
FLOOR
PLAN
HVAC -
DEMOLITION

DATE
6/16/11

PROJECT NUMBER
10136.01

SHEET NUMBER
M-300

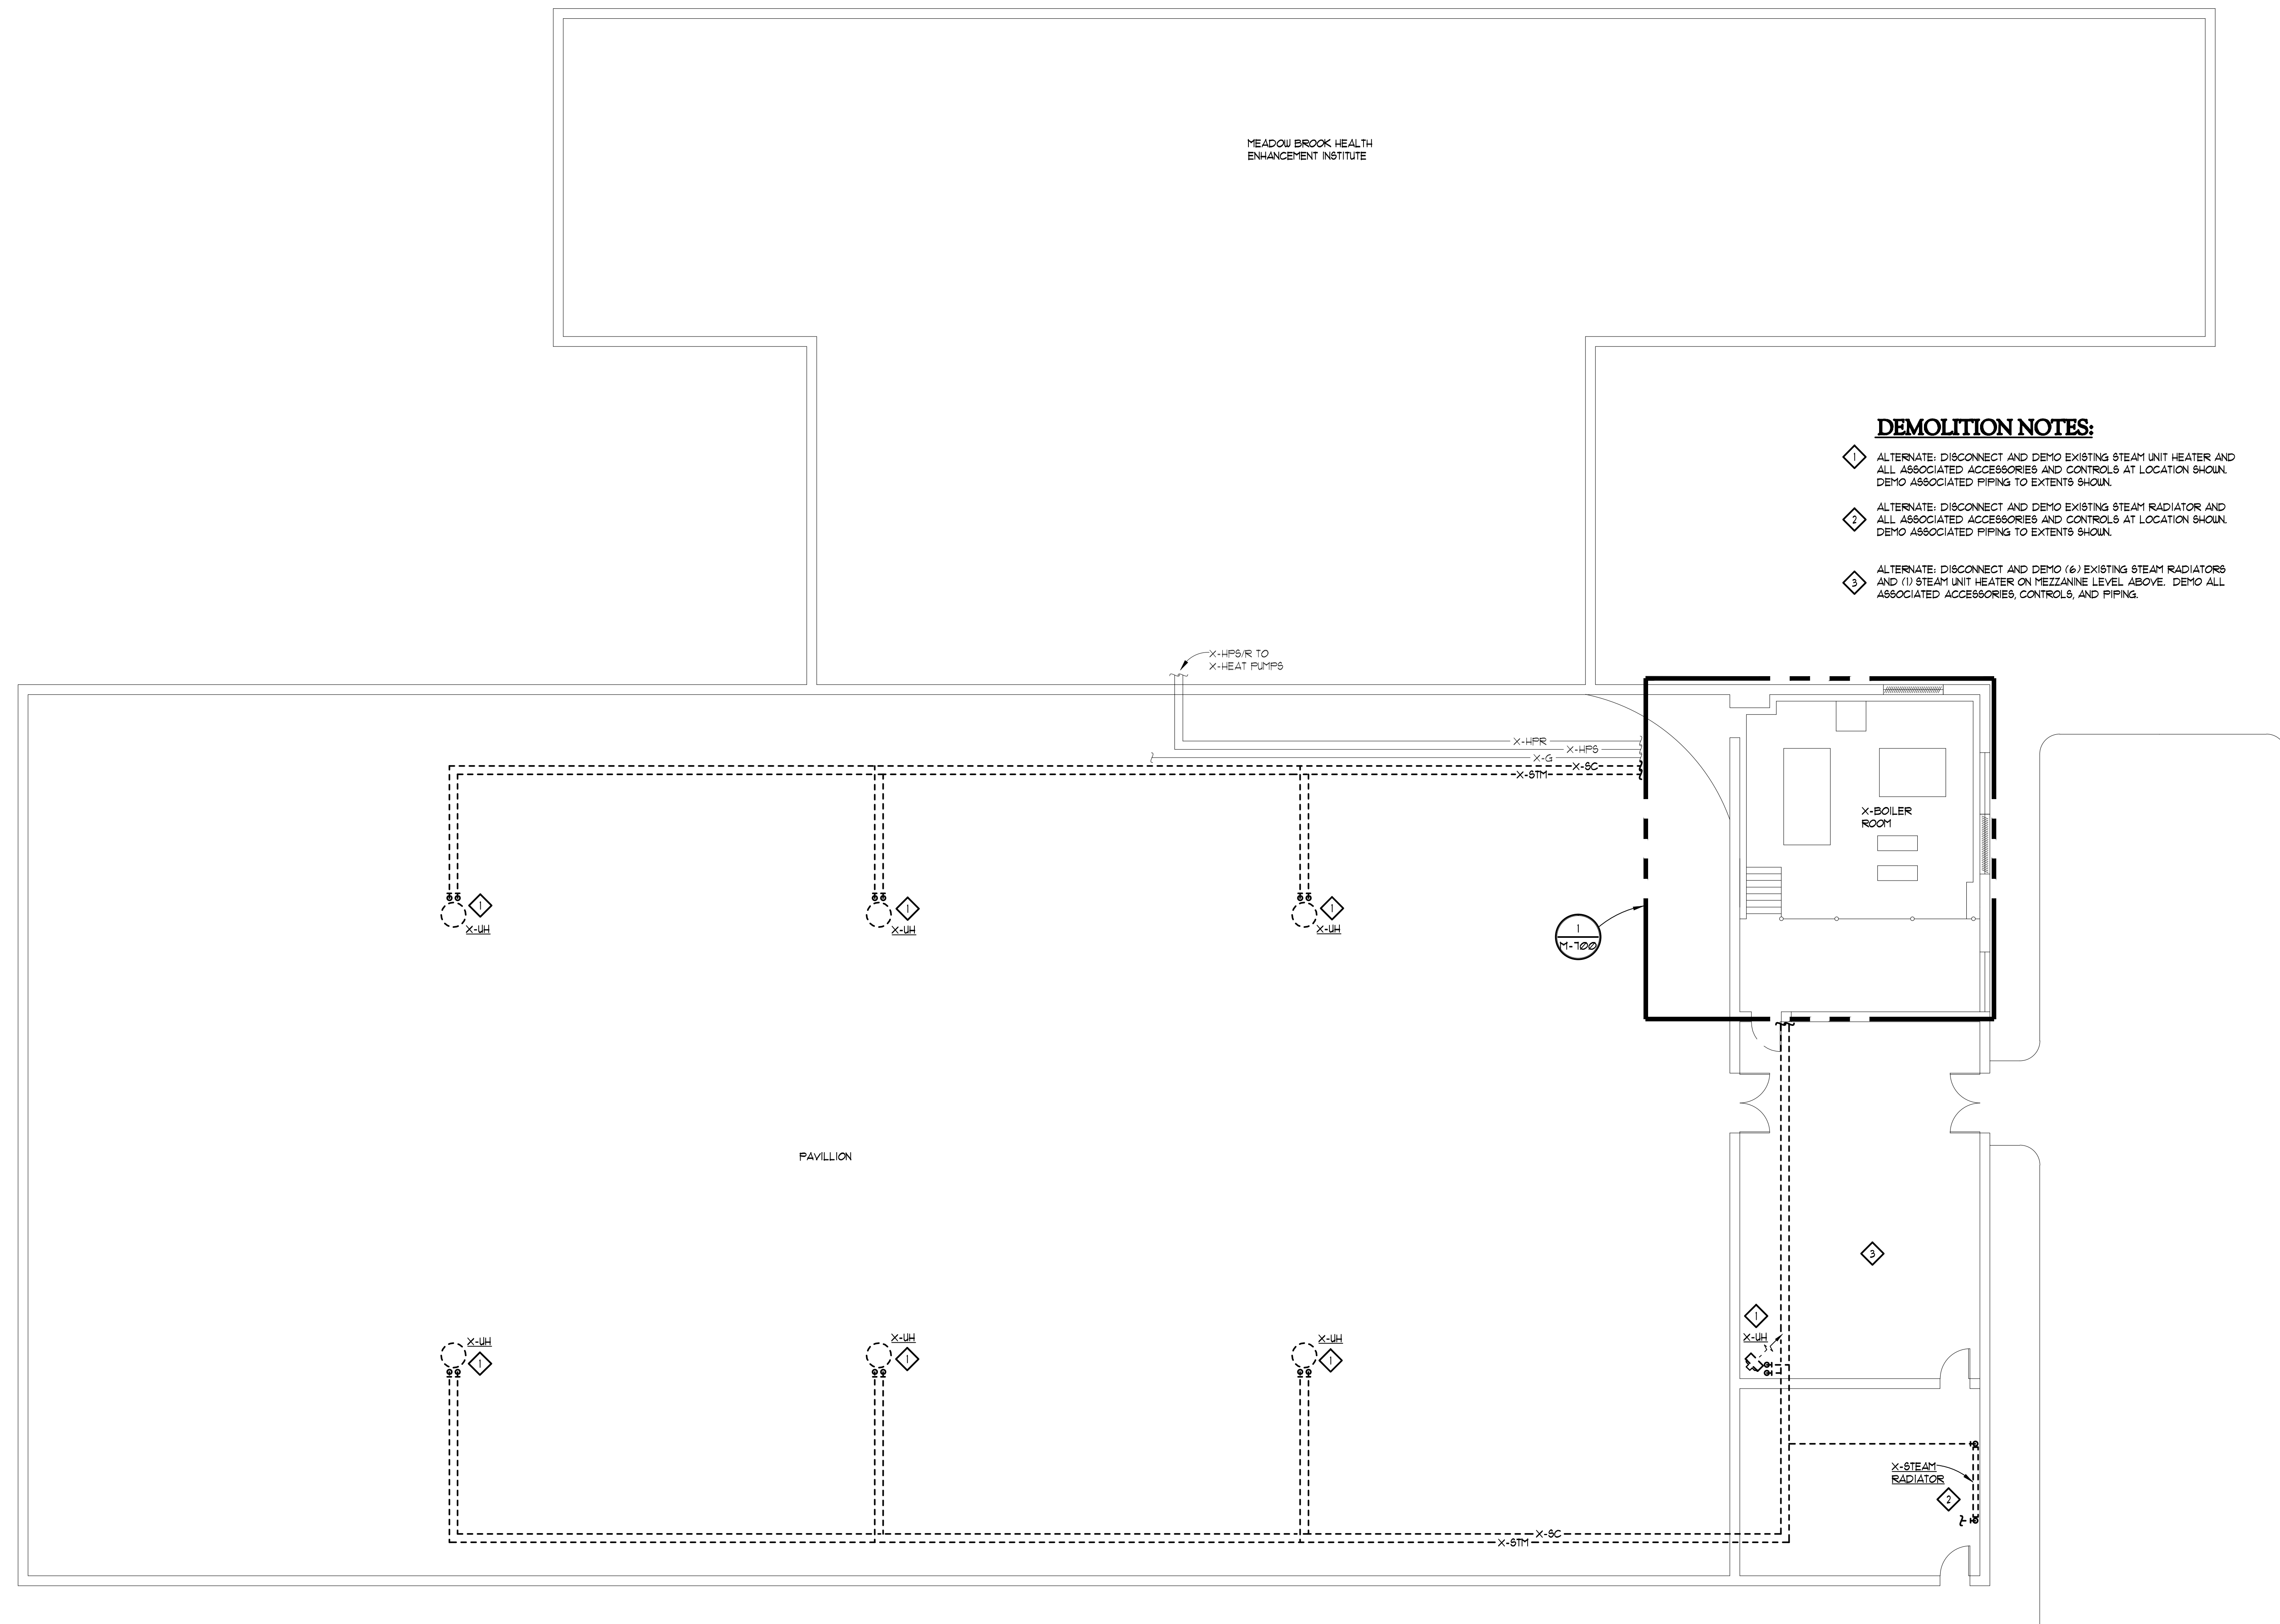


DEMOLITION NOTES:

X-HPS/R TO
X-HEAT PUMPS

X-BOILER
ROOM

X-STEAM
RADIATOR

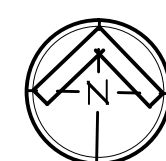

FLOOR PLAN HVAC - DEMOLITION - ALTERNATE

OWN

PROVED

 **MATRIX**
CONSULTING ENGINEERS, INC.
administrator@matrixinc.com
PHONE: (517) 487-2511
FAX: (517) 487-2544
1601 E. GRAND RIVER AVE.
LANSING, MI 48206
Matrix Project No. 10136.00

SUBJECT



HVAC MODIFICATIONS

NET DESCRIPTION

E

PROJECT NUMBER

ET NUMBER

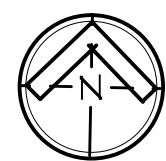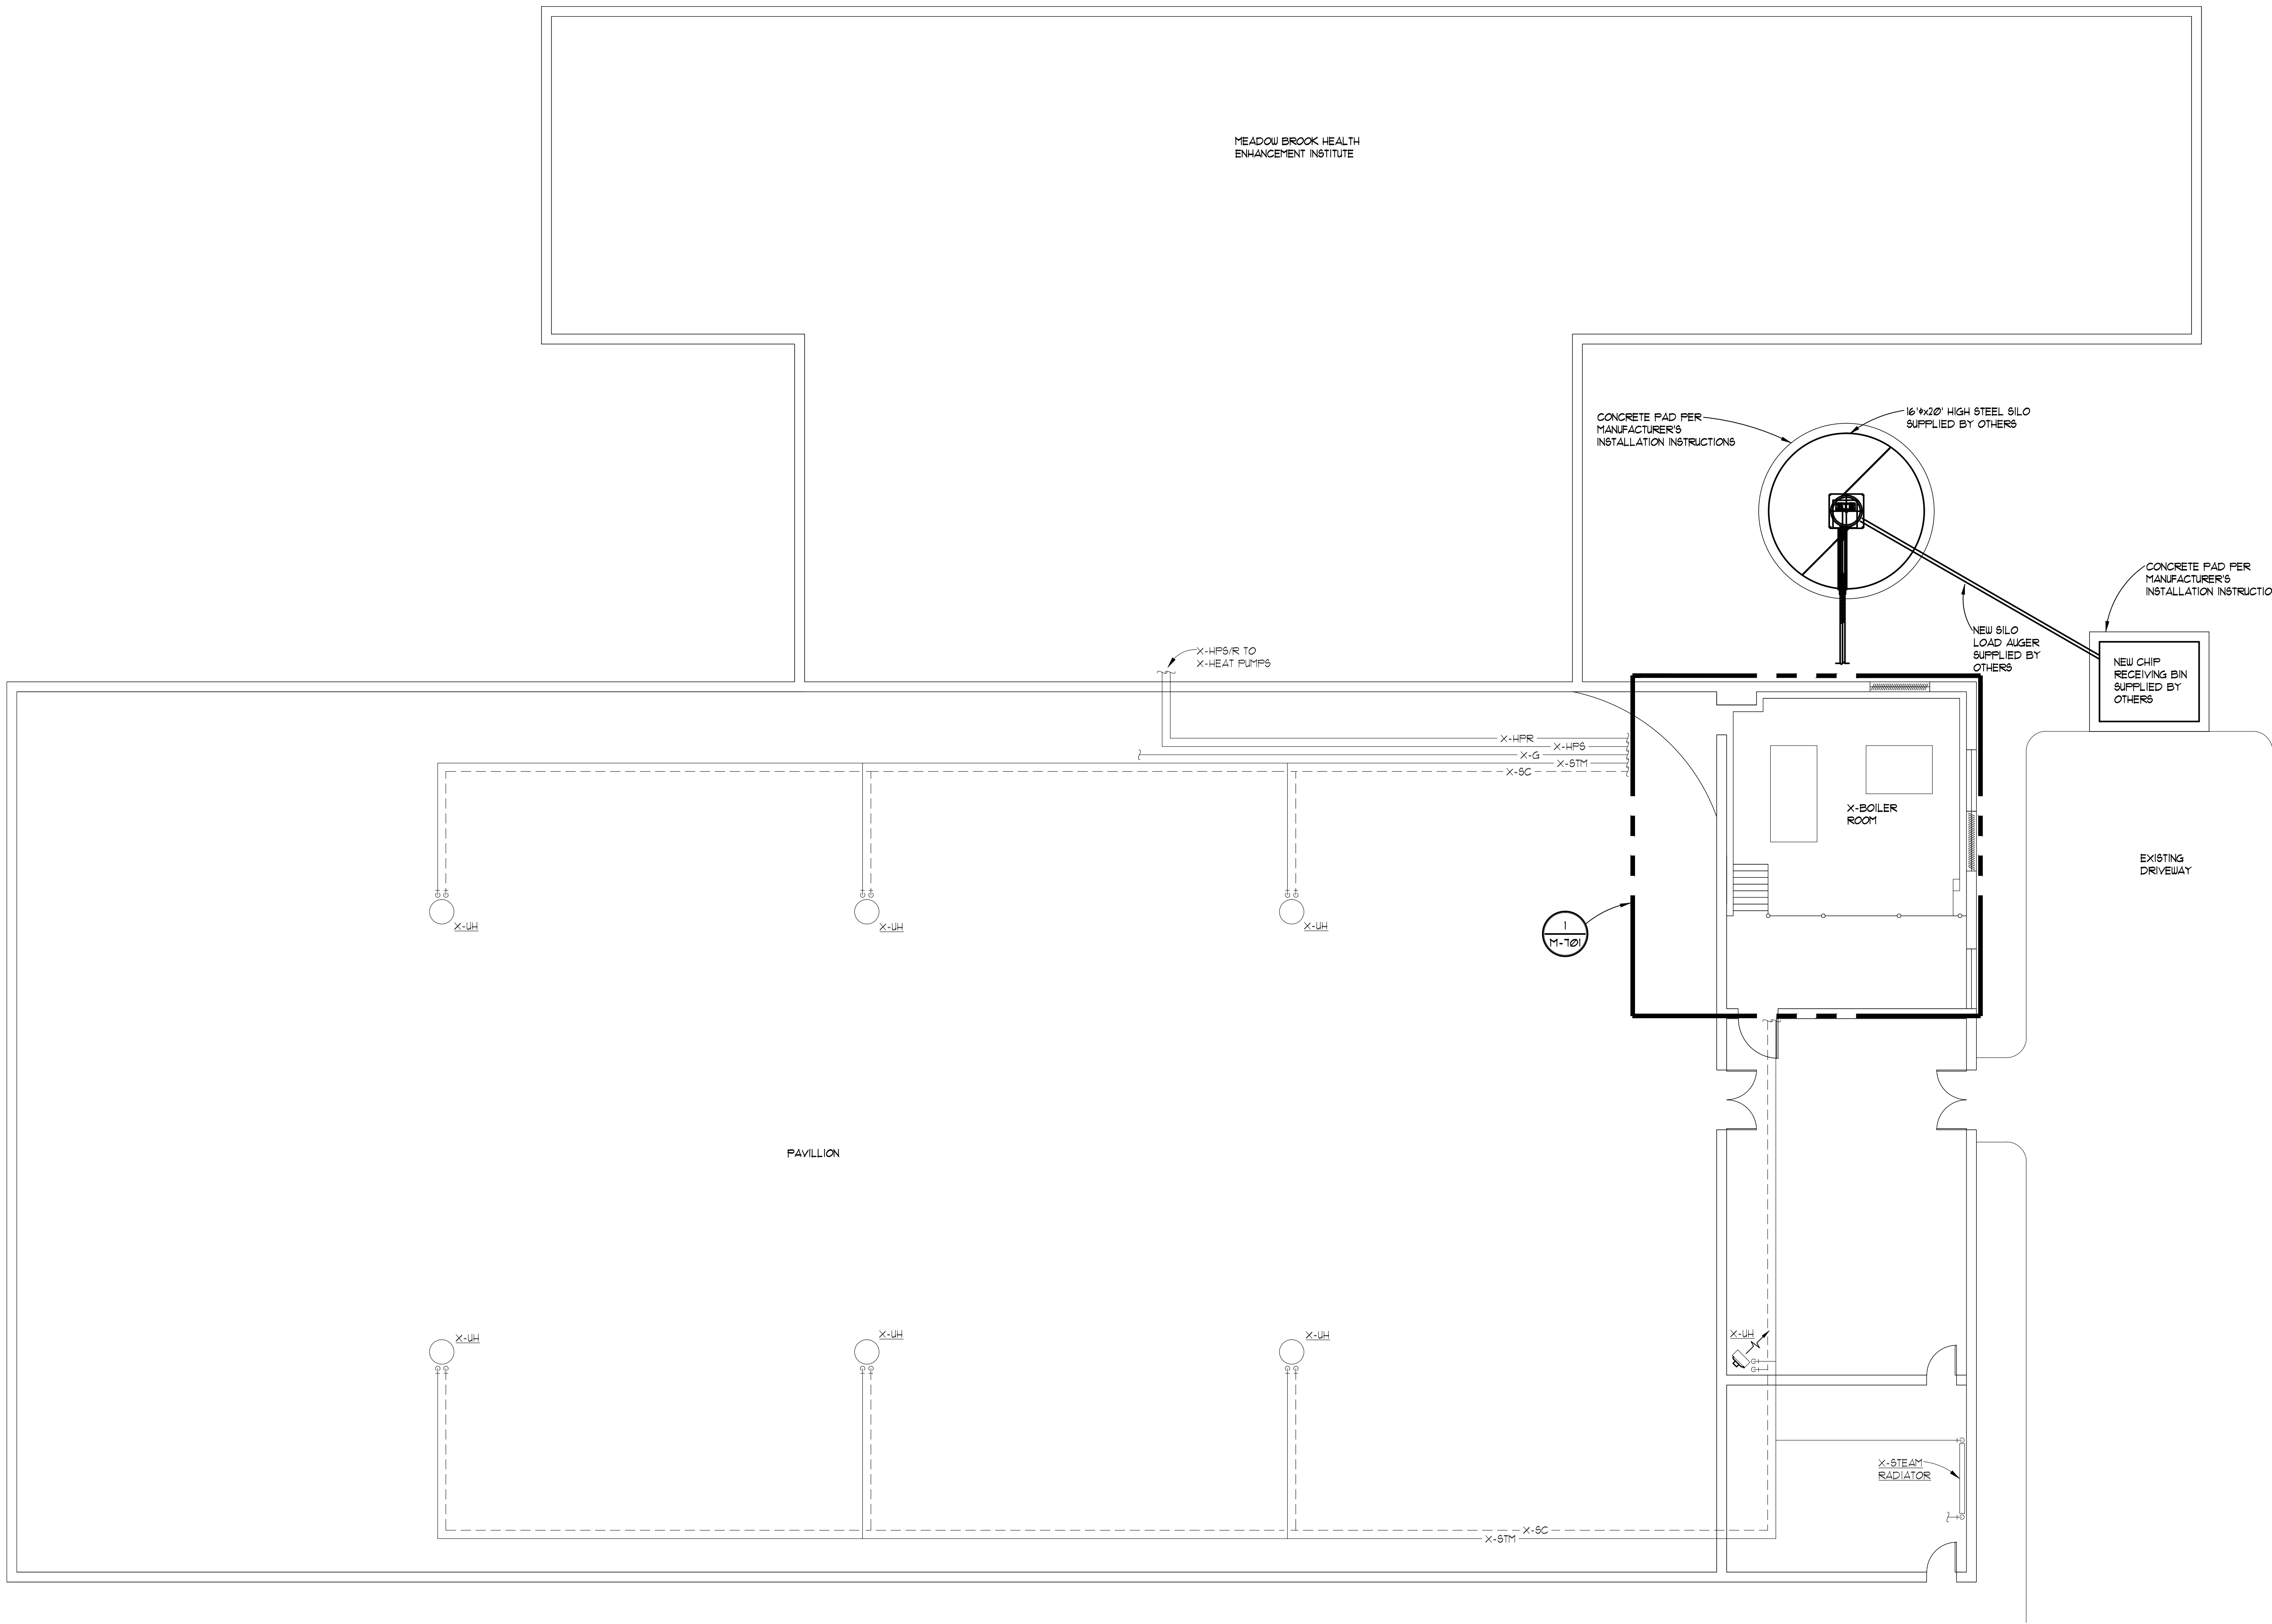

FLOOR PLAN HVAC - NEW

0 5 10 20
SCALE: 1/8" = 1'-0"

REVISIONS			

DRAWN
NAS

APPROVED
CTH

1601 E. GRAND RIVER AVE
LANSING, MI 48206
PHONE 617 487 2511
FAX 617 487 2544
admin@matrixeng.com
Matrix Project No. 10136.01

MATRIX
CONSULTING ENGINEERS, INC.

PROJECT

OAKLAND UNIVERSITY PAVILLION

HVAC MODIFICATIONS

SHEET DESCRIPTION

FLOOR
PLAN
HVAC -
NEW

DATE


6/16/11

PROJECT NUMBER

10136.01

SHEET NUMBER

M-400

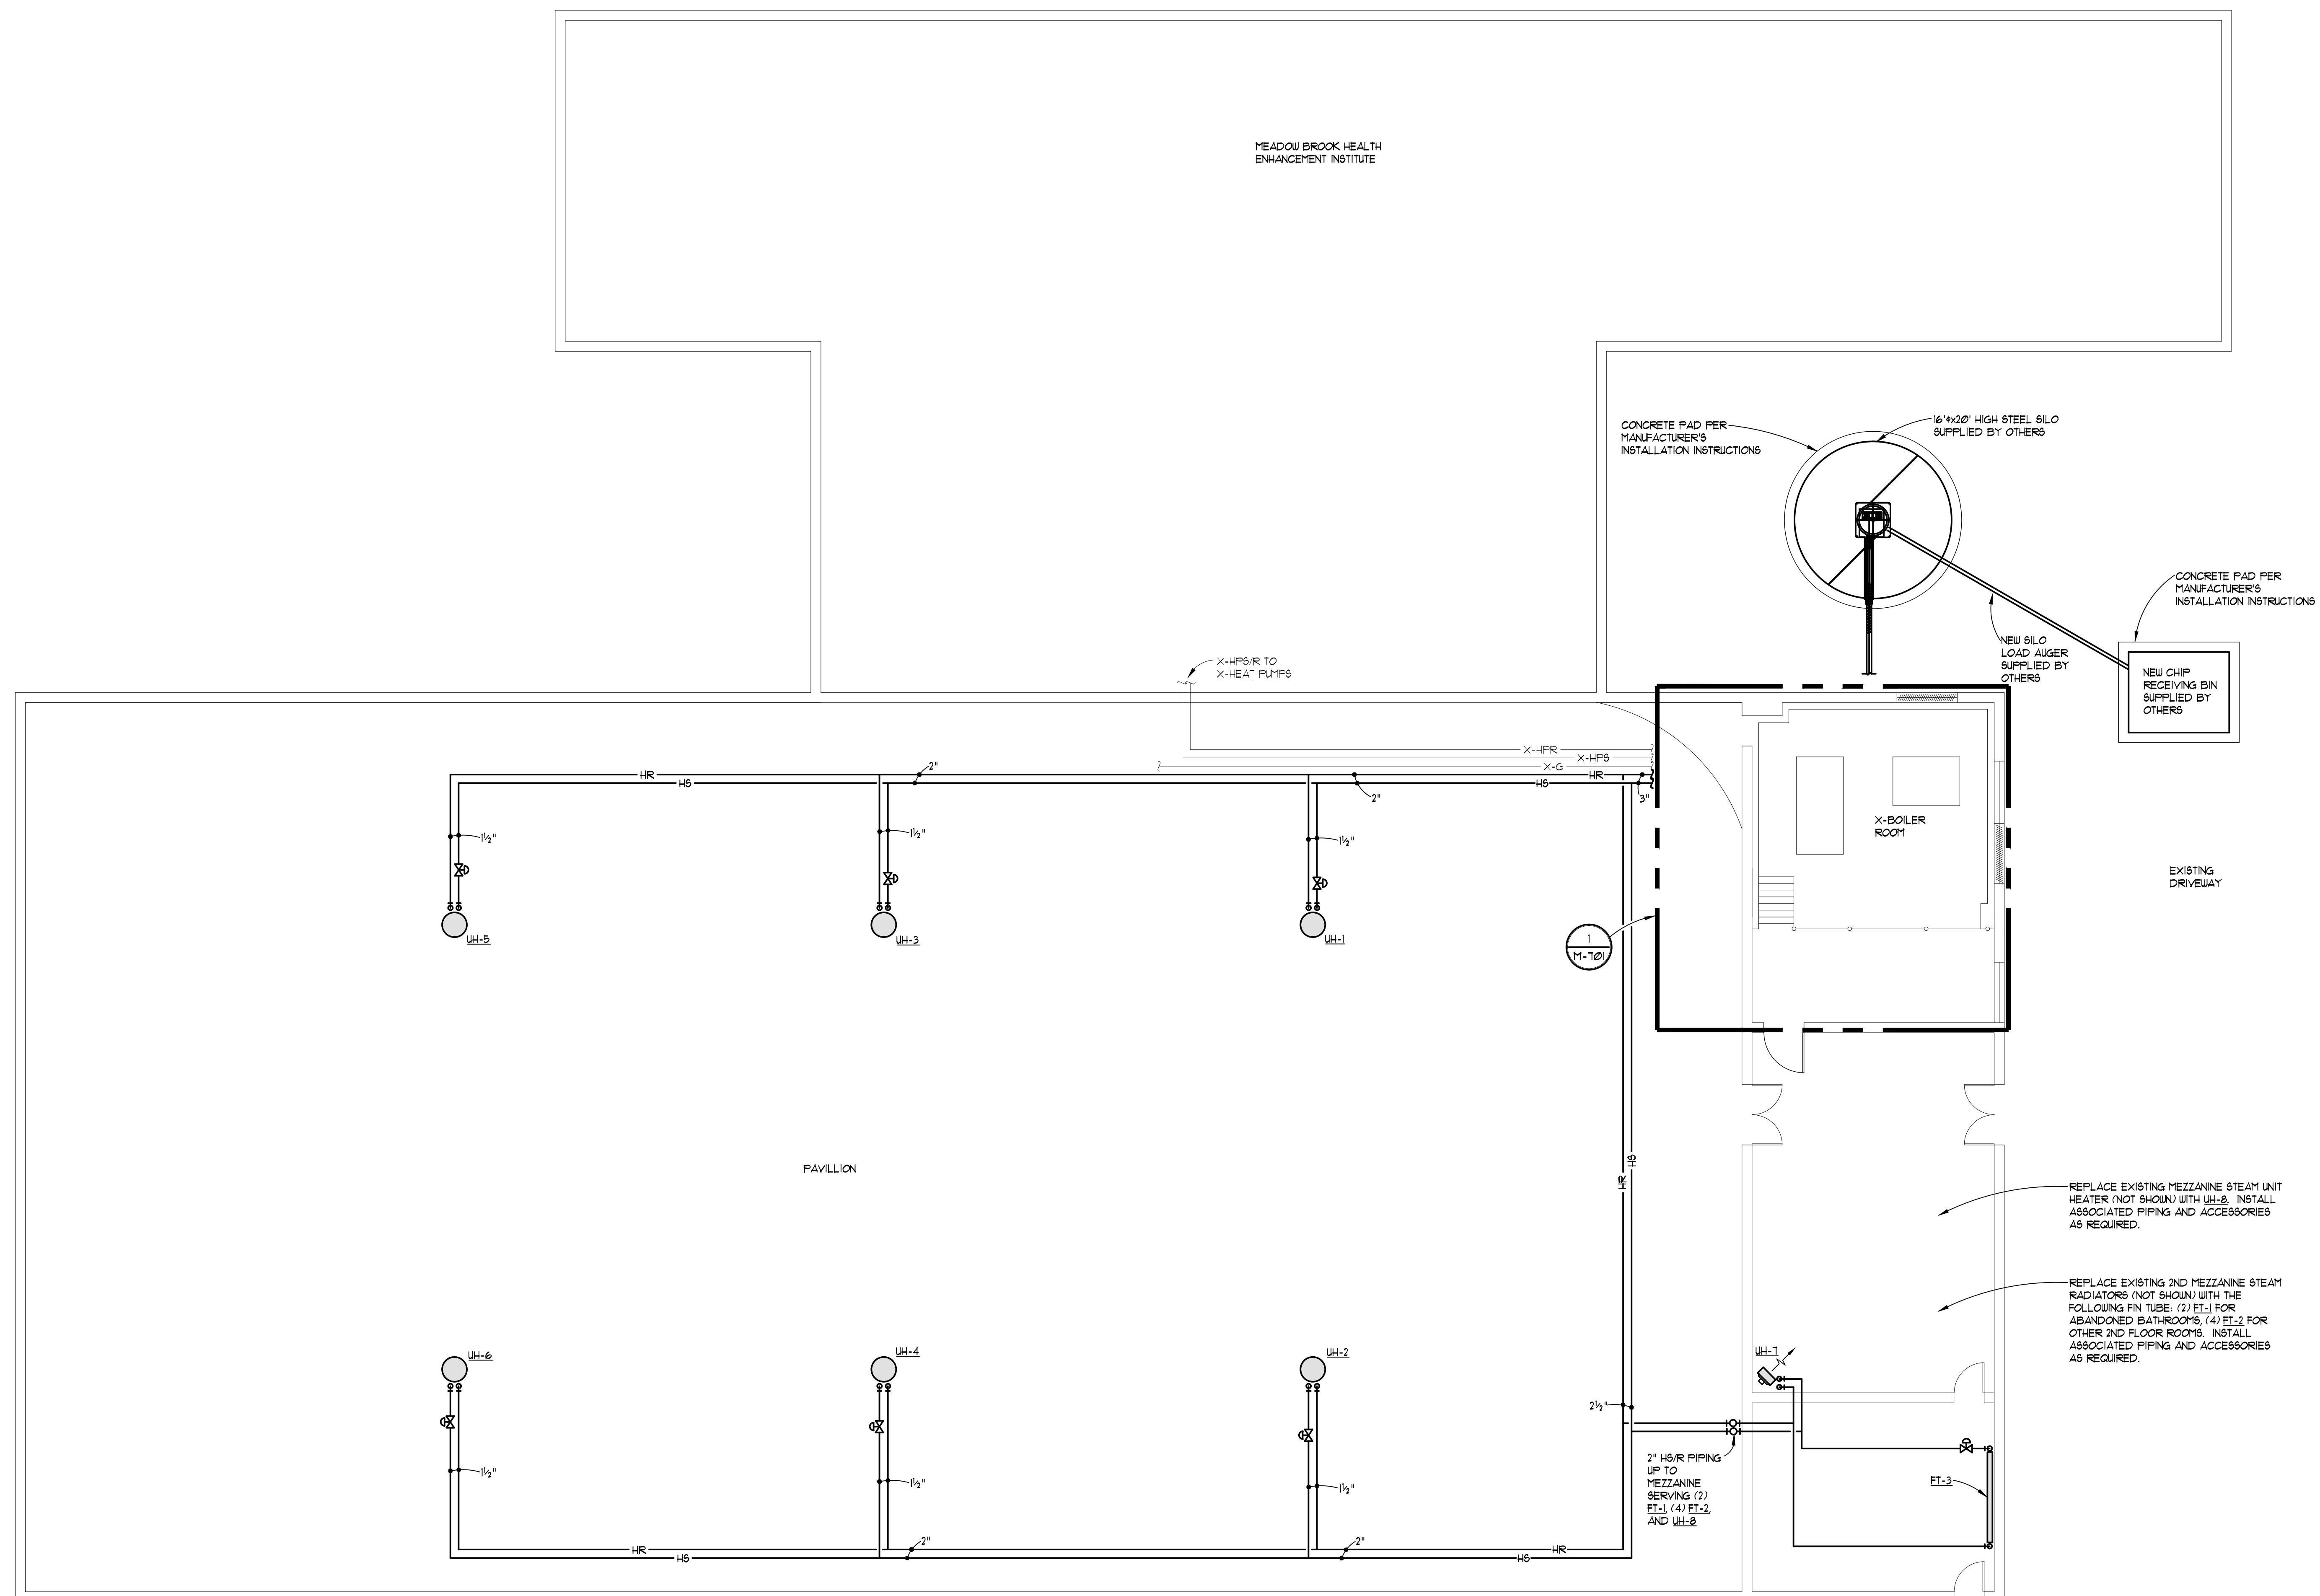[illegible]

DRAWN

NAS

MATRIX
CONSULTING ENGINEERS, INC.

1601 E. GRAND RIVER AVE.
LANSING, MI 48906


PHONE: (317) 487-2511
FAX: (317) 487-2544
administrator@matrixinc.com
Matrix Project No. 1013600

PROJECT
OAKLAND UNIVERSITY PAVILION
HVAC MODIFICATIONS


SHEET DESCRIPTION

FLOOR PLAN
HVAC -
NEW -
ALTERNATE

PROJECT NUMBER
10136.01

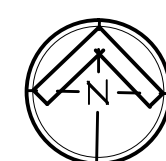

FLOOR PLAN HVAC - NEW - ALTERNATE

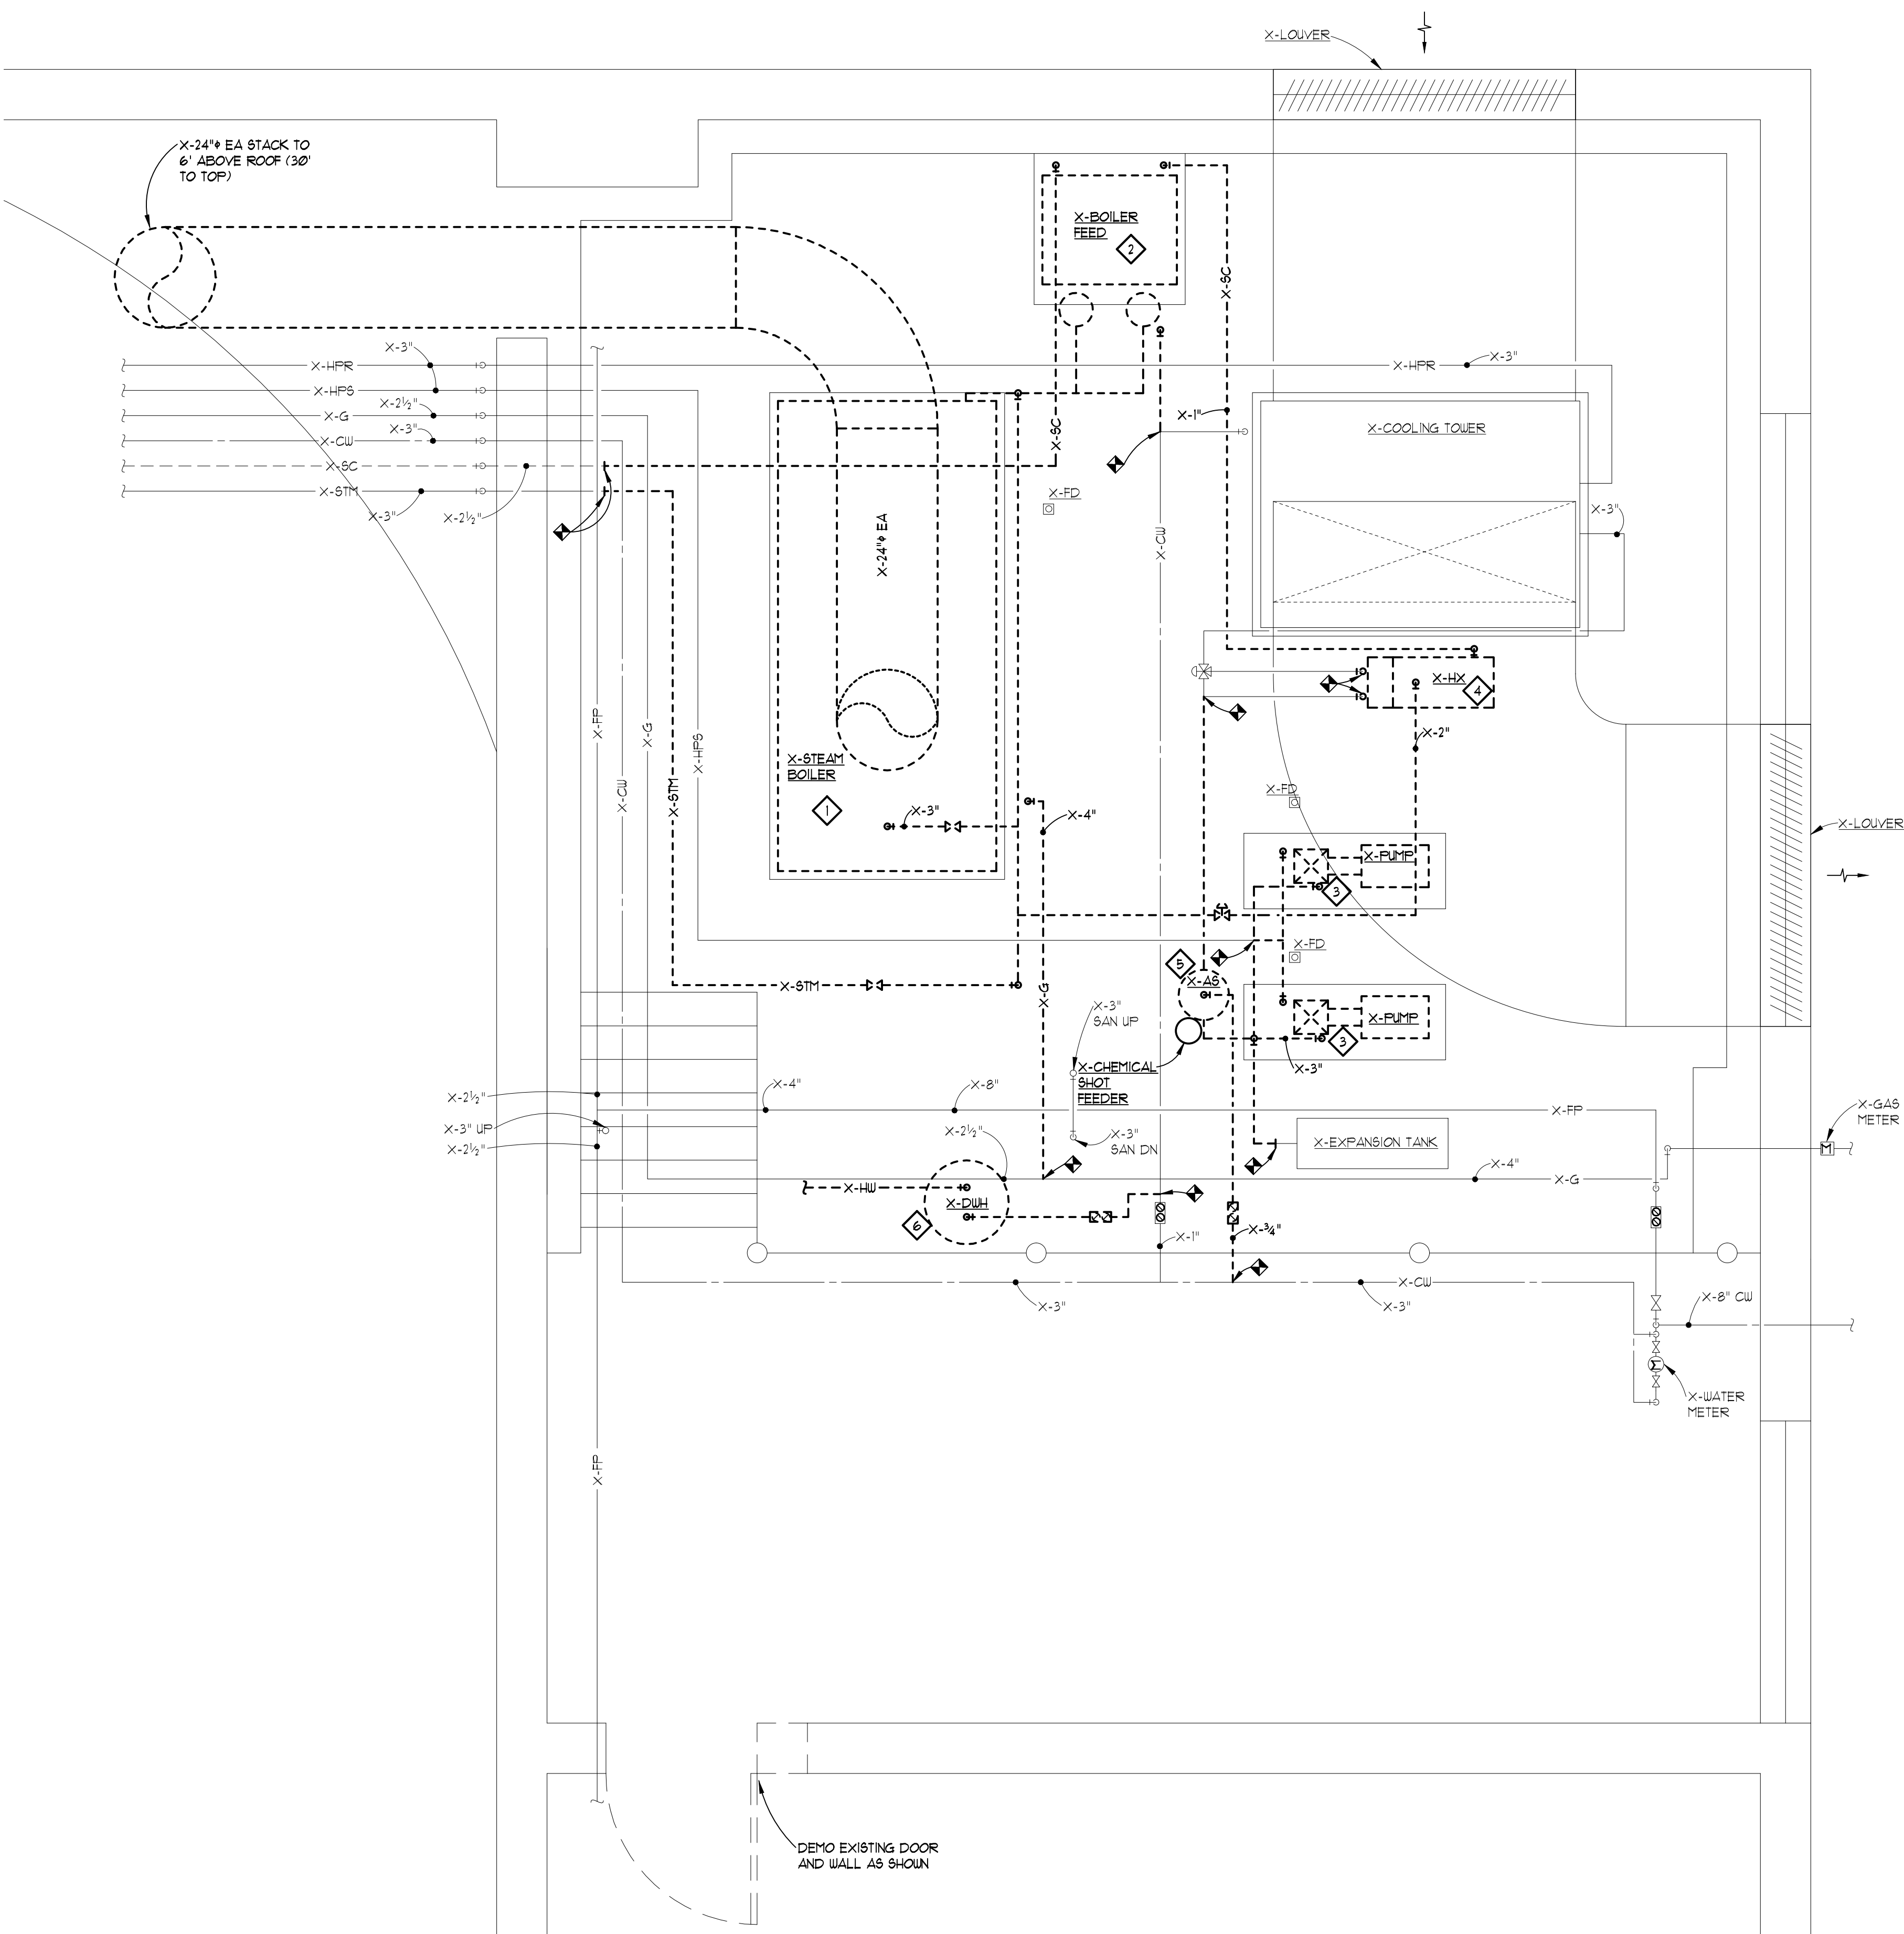

DEMOLITION NOTES:

- 1 DISCONNECT AND DEMO EXISTING BOILER AND ALL ASSOCIATED ACCESSORIES AND CONTROLS AT LOCATION SHOWN. DEMO ASSOCIATED PIPING TO EXTENTS SHOWN. DEMO ASSOCIATED EXISTING BOILER VENT AND PATCH WALL AND ROOF TO MATCH EXISTING.
- 2 DISCONNECT AND DEMO EXISTING BOILER FEED UNIT AND ALL ASSOCIATED ACCESSORIES AT LOCATION SHOWN. DEMO ASSOCIATED PIPING TO EXTENTS SHOWN. REMOVE EXISTING CONCRETE PAD AND PATCH FLOOR AS REQUIRED.
- 3 DISCONNECT AND DEMO EXISTING PUMP AND ALL ASSOCIATED ACCESSORIES AND CONTROLS AT LOCATION SHOWN. DEMO ASSOCIATED PIPING TO EXTENTS SHOWN. REMOVE EXISTING CONCRETE PAD AND PATCH FLOOR AS REQUIRED.
- 4 DISCONNECT AND DEMO EXISTING STEAM HEAT EXCHANGER AND ALL ASSOCIATED ACCESSORIES AT LOCATION SHOWN.
- 5 DISCONNECT AND RELOCATE EXISTING AIR SEPARATOR, CHEMICAL SHOT FEEDER AND ASSOCIATED ACCESSORIES AT LOCATION SHOWN. DEMO ASSOCIATED CW PIPING BACK TO MAIN.
- 6 DISCONNECT AND RELOCATE EXISTING DOMESTIC WATER HEATER AND ALL ASSOCIATED ACCESSORIES AND PIPING AT LOCATION SHOWN. DEMO ASSOCIATED BACKFLOW PREVENTER SERVING DWH.

1 ENLARGED BOILER ROOM HVAC - DEMOLITION
SCALE: 1/2"=1'-0"

REVISIONS			

DRAWN	NAS
APPROVED	CTH

**MATRIX**
CONSULTING ENGINEERS, INC

1601 E. GRAND RIVER AVE.
LANSING, MI 48906
PHONE (313) 487-2511
FAX (313) 487-2544
admin@matrixeng.com
Matrix Project No. 10136.00

OAKLAND UNIVERSITY PAVILION

HVAC MODIFICATIONS


SHEET DESCRIPTION	
ENLARGED BOILER ROOM HVAC - DEMOLITION	
DATE	6/16/11
PROJECT NUMBER	10136.01
SHEET NUMBER	M-700



③ ALTERNATE: EXISTING STM AND SC NOT TO BE REUSED. DEMO ALL EXISTING STM AND SC PIPING AT LOCATION SHOWN. 3" HS AND HR PIPING SHALL BE ROUTED WHERE STM AND SC IS SHOWN TO CONNECT HS/R PIPING IN BOILER ROOM TO NEW HS/R PIPING IN PAVILION AREA.

SHEET NUMBER

M-701

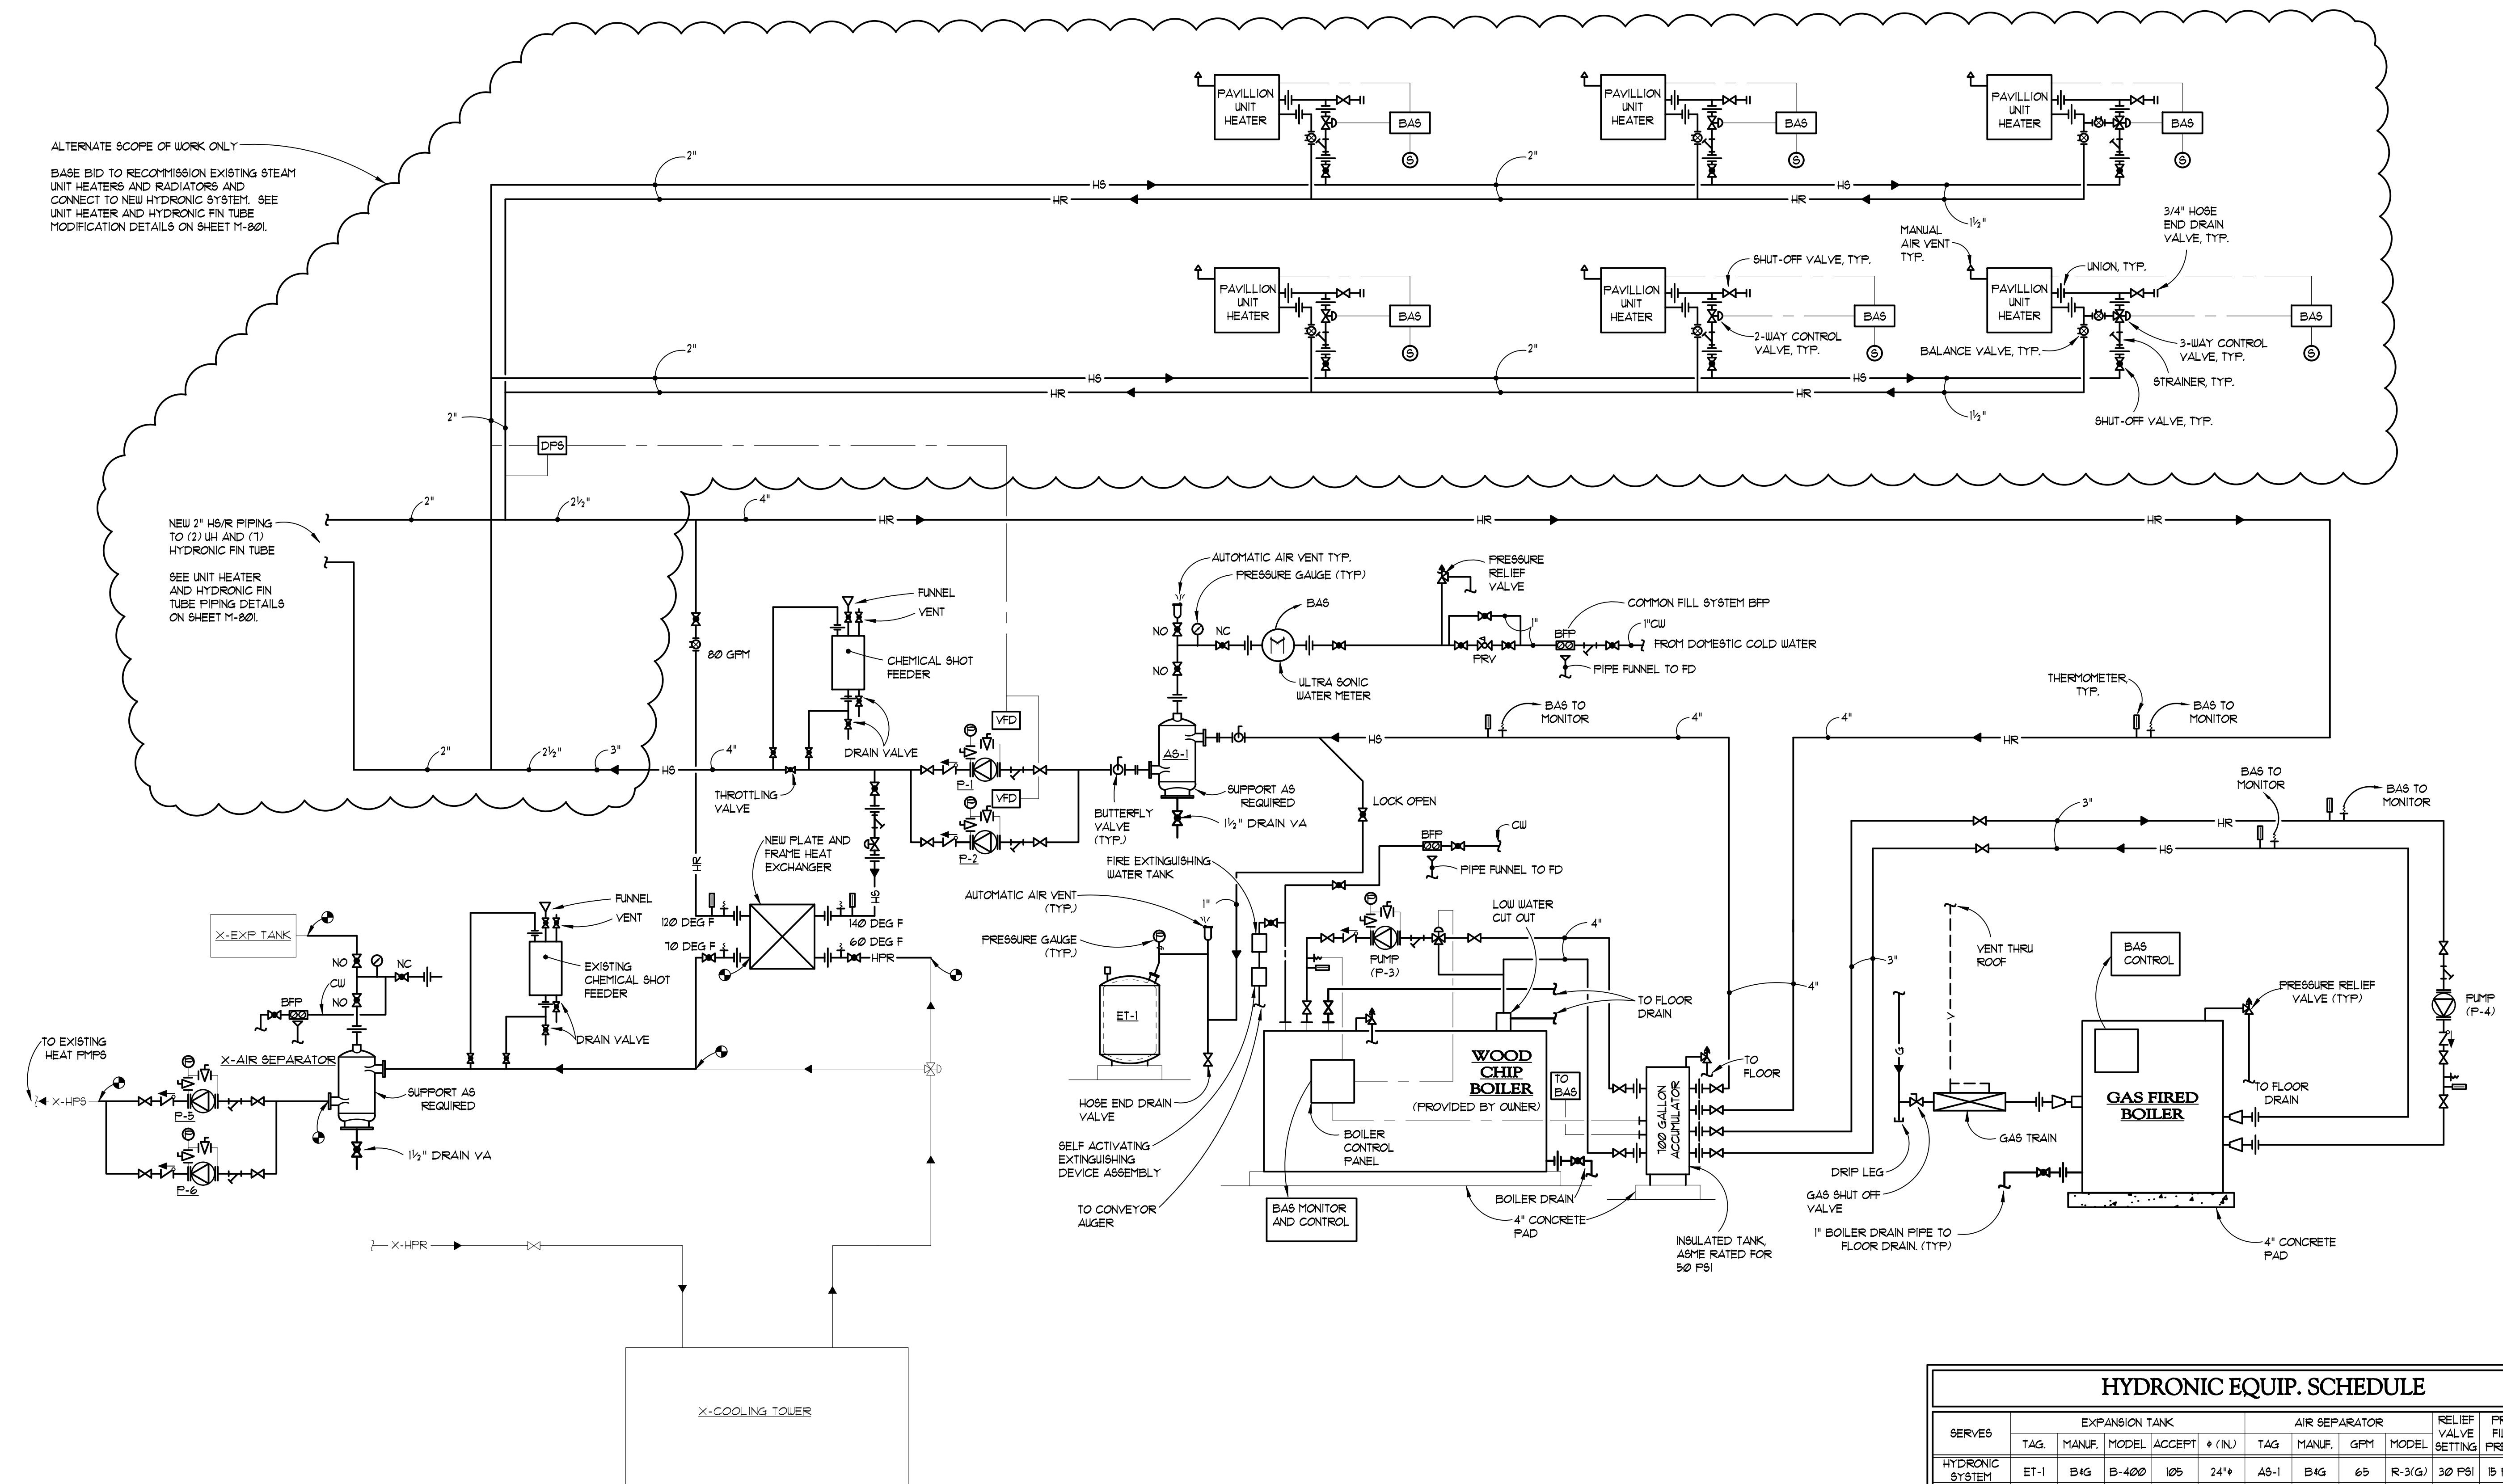

ALTERNATE SCOPE OF WORK ONLY
BASE BID TO RECOMMISSION EXISTING STEAM UNIT HEATERS AND RADIATORS AND CONNECT TO NEW HYDRONIC SYSTEM. SEE UNIT HEATER AND HYDRONIC FIN TUBE MODIFICATION DETAILS ON SHEET M-801.

NEW 2" HS/R PIPING TO (2) UH AND (1) HYDRONIC FIN TUBE
SEE UNIT HEATER AND HYDRONIC FIN TUBE PIPING DETAILS ON SHEET M-801.

HYDRONIC EQUIP. SCHEDULE												
SERVES	EXPANSION TANK					AIR SEPARATOR				RELIEF VALVE SETTING	PRV FILL PRESS	SYSTEM VOLUME
	TAG.	MANUF.	MODEL	ACCEPT	Ø (IN)	TAG	MANUF.	GPM	MODEL			
HYDRONIC SYSTEM	ET-1	B4G	B-400	105	24"	AS-1	B4G	65	R-3(G)	30 PSI	15 PSI	1650 GAL

HVAC PIPING DIAGRAM
SCALE: NTS

REVISIONS

DRAWN
NAS

APPROVED
CTH

MATRIX
CONSULTING ENGINEERS, INC.

1601 E. GRAND RIVER AVE.
LANSING, MI 48906
PHONE (313) 487-2511
FAX (313) 487-2544
administrators@matrixeng.com
Matrix Project No. 10136.00


OAKLAND UNIVERSITY PAVILION
HVAC MODIFICATIONS

SHEET DESCRIPTION
HVAC PIPING DIAGRAM


DATE
8/16/11

PROJECT NUMBER
10136.01


SHEET NUMBER
M-800

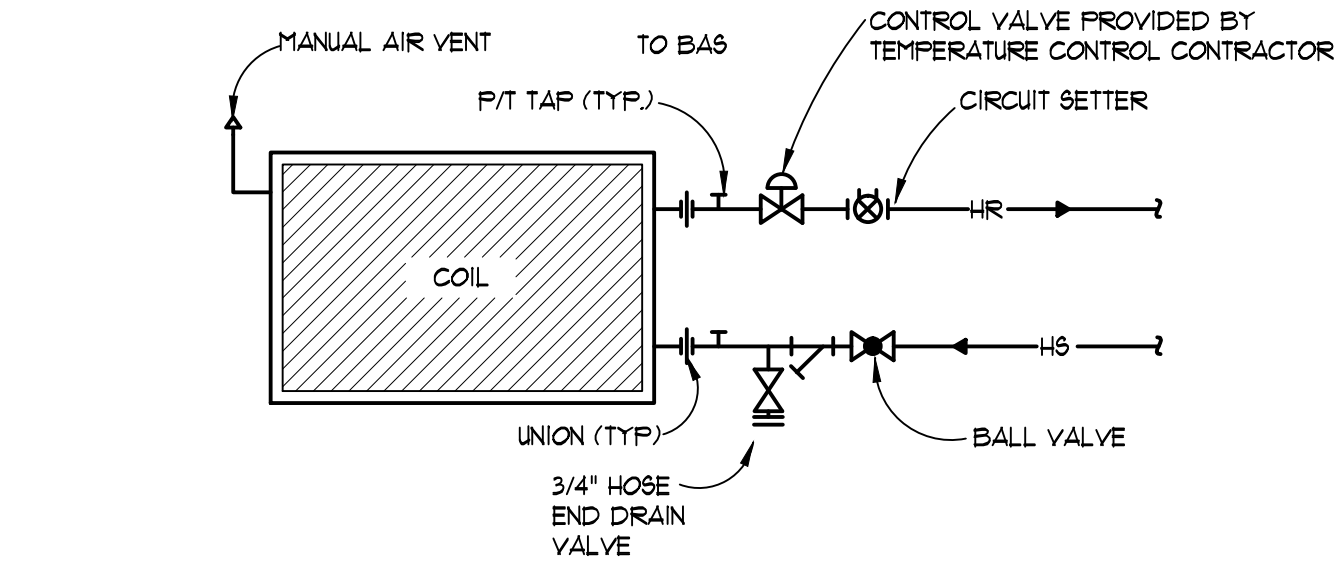


3
1'-0\"/>**ALTERNATE BID UNIT HEATER PIPING DETAIL**
SCALE: NTS

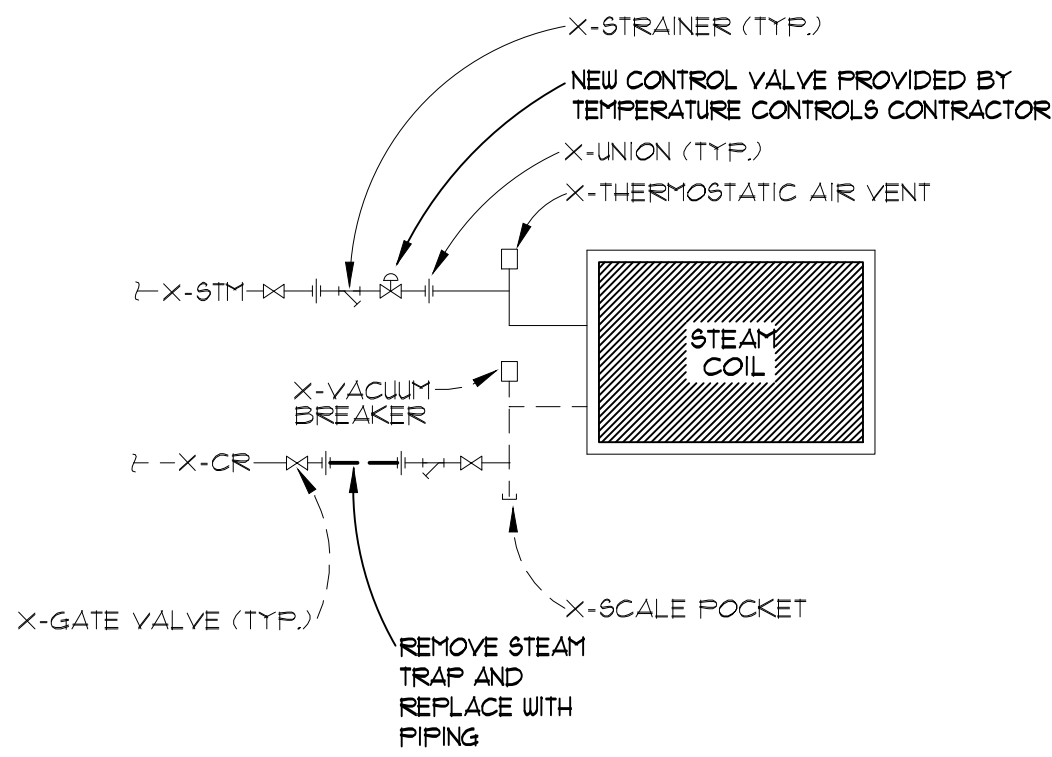

1
1'-0\"/>**BASE BID UNIT HEATER MODIFICATION PIPING DETAIL**
SCALE: NTS

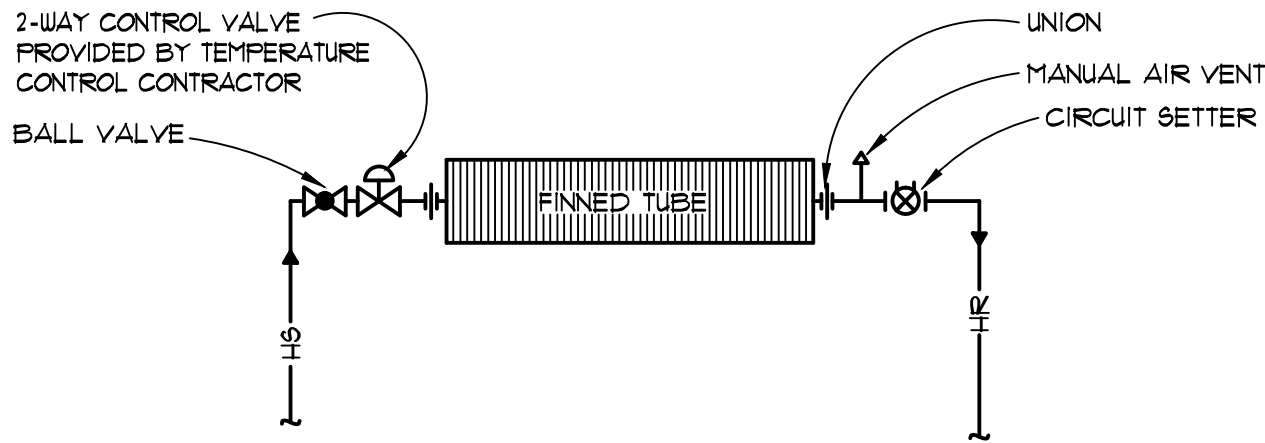

4
1'-0\"/>**ALTERNATE BID FINNED TUBE PIPING DETAIL**
SCALE: NTS

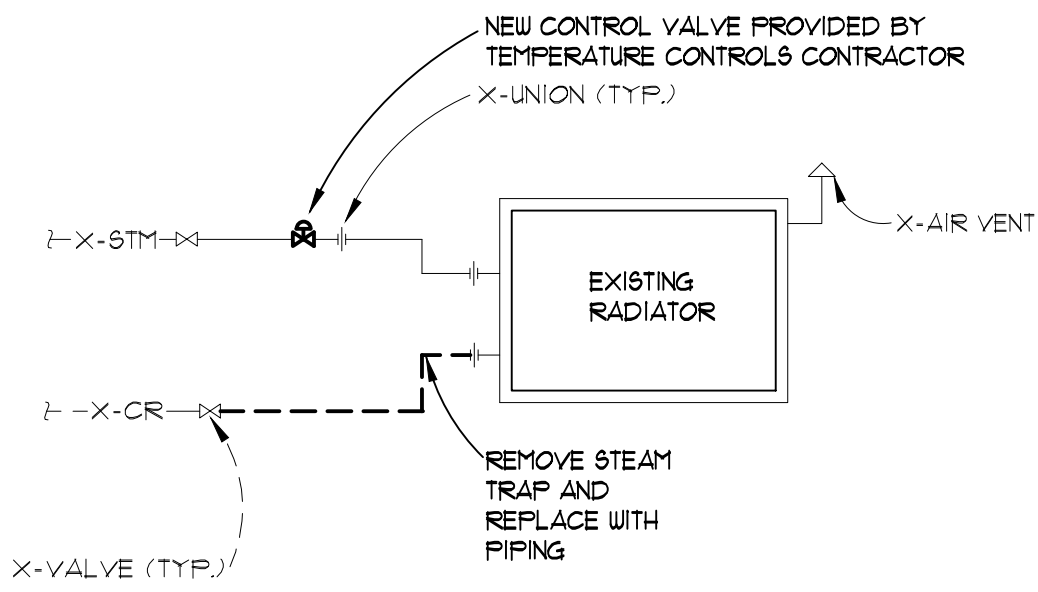

2
1'-0\"/>**BASE BID RADIATOR MODIFICATION PIPING DETAIL**
SCALE: NTS

REVISIONS			
DRAWN			
NAS			
APPROVED			
CTH			

**MATRIX**
CONSULTING ENGINEERS, INC.

1601 E. GRAND RIVER AVE.
LANSING, MI 48206
PHONE (617) 487-2511
FAX (617) 487-2544
administrator@matrixeng.com
Matrix Project No. 10136.01

OAKLAND UNIVERSITY PAVILION
HVAC MODIFICATIONS

SHEET DESCRIPTION
MECHANICAL
DETAILS

DATE
8/16/11

PROJECT NUMBER
10136.01

SHEET NUMBER
M-801

FIN TUBE RADIATION SCHEDULE							
TAG	LENGTH, FT.	ENCLOSURE	CAPACITY BTU/HR.	EWТ °F	LWT °F	GPM	NOTES
FT-1	2	18S	2,500	180	160	0.3	1,2
FT-2	7	18S	8,800	180	160	0.9	1,2
FT-3	9	18S	11,200	180	160	1.2	1,2

NOTES:
1. BASED ON TRANE
2. SLOPING TOP ENCLOSURE

WOOD-FIRED BOILER SCHEDULE																					
TAG	MODEL	LOCATION	TYPE	FLUE SIZE	HEAT OUTPUT	BOILER HORSE-POWER	OUTPUT EFFICIENCY	WATER FLOW RATE	WATER-SIDE PRESSURE DROP	BOILER WATER VOLUME	EWТ	LWT	WATER BOILER DIMENSIONS (in)			ELECTRICAL					NOTES
				(in)	(MBH)	(HP)	(%)	(GPM)	(FT)	(GAL)	(°F)	(°F)	LENGTH	WIDTH	HEIGHT	VOLTS	PHASE	KW	DISC.	STRTR	
WB-1	KRT-300	BOILER ROOM	WOOD BURNING BOILER WITH ROTATION COMBUSTION CHAMBER	12	1,024	30.6	92	105	5	238	140	160	134.4	52.4	82	208	3	3.6	EC	EC	1,2,3

NOTES: 1. BASED ON: KOB PYROT
2. ACCESSORIES:
A) DE-ASHING SYSTEM
B) FIRE EXTINGUISHING SYSTEM
C) ECOTRONIC CONTROL SYSTEM
3. BOILER PRE-PURCHASED BY OWNER.

GAS-FIRED BOILER SCHEDULE																					
TAG	MODEL	LOCATION	TYPE	FLUE SIZE	INPUT ENERGY	HEAT OUTPUT	BOILER HORSE-POWER	OUTPUT EFFICIENCY	WATER FLOW RATE	WATER-SIDE PRESSURE DROP	EWТ	LWT	WATER BOILER DIMENSIONS (in)			ELECTRICAL					NOTES
				(in)	(MBH)	(MBH)	(HP)	(%)	(gmp)	(FT)	(°F)	(°F)	LENGTH	WIDTH	HEIGHT	VOLTS	PHASE	FLA	DISC.	STRTR	
B-1	KBN601	BOILER ROOM	GAS FIRED CONDENSING BOILER	4	600	567	16.9	94	38	30	150	180	36.25	15.5	42.5	120	1	15.5	EC	MAN	1,2

NOTES: 1. BASED ON: LOCHINVAR
2. ACCESSORIES:
A) MANUAL RESET HIGH LIMIT CONTROL
B) MANUAL RESET LOW WATER CUTOFF
C) DIRECT VENT SIDEWALL WITH CONCENTRIC VENT KIT

FLUID PUMP SCHEDULE															
TAG	SERVES	LOCATION	MODEL	TYPE	PUMP				MOTOR						NOTES
					GPM	HEAD (FT)	IMP. DIA.	% EFF.	RPM	HP	VOLT	PHASE	DISC.	STRTR.	
P-1	HYDRONIC SYSTEM	BOILER ROOM	SERIES 80	INLINE	100	40	6.875	55.8%	1750	3.0	208	3	EC	EC	1,2,3
P-2	HYDRONIC SYSTEM	BOILER ROOM	SERIES 80	INLINE	100	40	6.875	55.8%	1750	3.0	208	3	EC	EC	1,2,3
P-3	WOOD FIRED BOILER (WB-1)	BOILER ROOM	SERIES 60	INLINE	105	25	5.25	70.7%	1750	1.5	208	3	EC	EC	1,2
P-4	GAS FIRED BOILER (B-1)	BOILER ROOM	SERIES 60	INLINE	38	30	5.625	56.0%	1750	1.0	208	3	EC	EC	1,2
P-5	HEAT PUMP LOOP	BOILER ROOM	SERIES 80	INLINE	80	60	8.5	51.3%	1750	3.0	208	3	EC	EC	1,2
P-6	HEAT PUMP LOOP	BOILER ROOM	SERIES 80	INLINE	80	60	8.5	51.3%	1750	3.0	208	3	EC	EC	1,2

NOTES: 1. BASED ON: BELL & GOSSETT
2. ABBREVIATIONS
EC - ELECTRICAL CONTRACTOR
ETHL - ETHELEYNE GLYCOL
PROP. - PROPYLENE GLYCOL
MAN - MANUFACTURER
NA - NOT APPLICABLE
COND - CONDENSATE
3. CONTROLLED WITH VFD

HYDRONIC UNIT HEATER SCHEDULE																			
TAG	MODEL	LOCATION	CFM	MIN. MBH	ROWS	EAT (°F)	LAT (°F)	EWT (°F)	LWT (°F)	GPM	MAX. ΔP (FT.)	ELECTRICAL							REMARKS
												VOLTAGE	PHASE	HP	FLA	WATTS	DISC BY	STRTR BY	
UH-1	UHSA-166P	PAVILLION	2620	97.7	N/A	60	95	180	160	10	0.58	115	1	1/6	-	-	EC	TC	
UH-2	UHSA-166P	PAVILLION	2620	97.7	N/A	60	95	180	160	10	0.58	115	1	1/6	-	-	EC	TC	
UH-3	UHSA-166P	PAVILLION	2620	97.7	N/A	60	95	180	160	10	0.58	115	1	1/6	-	-	EC	TC	
UH-4	UHSA-166P	PAVILLION	2620	97.7	N/A	60	95	180	160	10	0.58	115	1	1/6	-	-	EC	TC	
UH-5	UHSA-166P	PAVILLION	2620	97.7	N/A	60	95	180	160	10	0.58	115	1	1/6	-	-	EC	TC	
UH-6	UHSA-166P	PAVILLION	2620	97.7	N/A	60	95	180	160	10	0.58	115	1	1/6	-	-	EC	TC	
UH-7	UHSA-60S	EAST AREA OPEN SPACE	815	27.4	N/A	60	95	180	160	2.8	0.16	115	1	1/20			EC	TC	
UH-8	UHSA-42S	MEZZANINE AREA OPEN SPACE	590	15.0	N/A	60	95	180	160	1.5	0.04	115	1	1/20			EC	TC	

NOTES:
1. BASED ON: TRANE
2. ACCESSORIES:
T - UNIT MOUNTED THERMOSTAT
R - REOSTAT (SOLID STATE CONTROLLER)
3. ABBREVIATIONS
EC - ELECTRICAL CONTRACTOR
MC - MECHANICAL CONTRACTOR
TC - TEMPERATURE CONTROL CONTRACTOR

LOUVER SCHEDULE											
TAG	FUNCTION	SERVES	MAKE & MODEL	NECK SIZE		DEPTH	INLET FREE AREA (FT2)	CFM	PRESSURE DROP (IN WC)	SCREEN	REMARKS
				WIDTH	HEIGHT						
LV-1	COMBUSTION AIR	BOILER ROOM	L6375D	36"	24"	6"	2.75	1375	0.03	BIRD	1

NOTES:
1. BASED ON: RUSKIN

HEAT EXCHANGER SCHEDULE														
TAG	SERVES	LOCATION	TYPE	CAPACITY (MBH)	HEAT PUMP LOOP				BOILER LOOP				NOTES	
					EWТ °F	LWT °F	GPM	WPD (FT. HD.)	EWТ °F	LWT °F	GPM	WPD (FT. HD.)		
HX-1	HEAT PUMP LOOP	BOILER ROOM	BRAZED PLATE STAINLESS STEEL	350	60	70	80	5.6	140	120	35	1.3		

BASED ON: BELL & GOSSETT

REVISIONS			

DRAWN
NAS

APPROVED
CTH

MATRIX

CONSULTING ENGINEERS, INC

1601 E GRAND RIVER AVE
LANSING, MI 48906
PHONE (317) 487-2511
FAX (317) 487-2544
administrators@matrixeng.com
Matrix Project No. 10136.00

PROJECT

OAKLAND UNIVERSITY PAVILION

HVAC MODIFICATIONS

SHEET DESCRIPTION
MECHANICAL
SCHEDULES

DATE
6/16/11

PROJECT NUMBER
10136.01

SHEET NUMBER
M-900

